


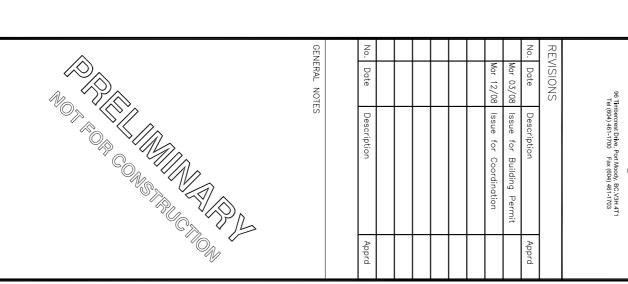

| DR. | PR | SSI | 유 | | |
|-------------------------|-------------------------|------------------|-----------------------|-------------|------------------------|
| PLANTING PLAN & LEGENDS | PROJECT NUMBER CCD5-102 | ISSUED MAR 03/08 | снескер ву DC | COLWOOD, BC | AQUATTRC LOWRISE 1H |
| N & LEGENDS | DRAWN BY | DATE MAR 03/08 | SCALE 1:200 METRIC | | ± 80 |

EXISTING TREES AND SHRUBS, TYPICAL





#1505 - 800 West Pender St. Vancouver, British Columbia Canada V6C 2V6 Telephone:(604) 685-3271 Fax:(604) 685-3278

POON MCKENZIE ARCHITECTS

PLANTING NOTES

the Contractor is to check and verify all dimensions and report any discrepancies to the Architect prior to construction. this drawing is the property of the Architect and reproduction is prohibited without his prior written approval.

this drawing is not to be used for construction unless properly signed and sealed by the Archite this drawing is not to be scaled.

AT LEAST 2 WEEKS PRIOR TO ANTICIPATED PLANTING TIME.

SERVICES PRIOR TO DIGGING TREE PITS.

CHEWINGS FESCUE, 35% HARD FESCUE AND 15% PERENNIAL

CONSULTANTS LTD.

AG-GROWN TREES WILL NOT BE ACCEPTED.